

Correct Maps

From: Niall McCann <Niall.McCann@keystonelaw.co.uk>

Sent: Monday, February 23, 2026 5:15 PM

To: Gardiner Neil: H&F <Neil.Gardiner@lbhf.gov.uk>

Subject: RE: The Hurlingham Club. Timed Premises Licence Application.

Hi Neil

Just checking the Agenda and the interior ground floor plan on the existing permanent licence at page 48 is correct but pages 49 to 51 show a completely different premises – seems to be The Prince SW6. I attach the correct plans. Don't think that it makes a material difference but just in case the Committee are confused!


Best,

[Niall McCann](#) | Partner

Recognised by Chambers for Licensing & The Legal 500 as a 'Leading Individual' for Betting, Licensing & Gambling 2026

DISCLAIMER
 THE HARD COPY ACCOMPANYING THE ELECTRONIC DATA IS THE LEGAL
 TRANSMISSION OF INFORMATION. THE ELECTRONIC DATA ARE ISSUED ONLY
 FOR INFORMATION AND ARE NOT TO BE USED FOR ANY OTHER PURPOSES OR FOR
 ANY CONSEQUENCE RESULTING FROM THE USE OR ALTERATION OF THE
 INFORMATION IS ACCEPTED.
 THE CLIENT AGREES TO CHANGE DURING THE DESIGN
 DEVELOPMENT PROCESS.
 FOR STRUCTURAL DETAILS REFER TO STRUCTURAL ENGINEERS DRAWINGS.
 ALL DIMENSIONS ARE IN METRES UNLESS OTHERWISE STATED. DIMENSIONS
 ARE INDICATIVE ONLY AND TO BE CONFIRMED BY SPECIALIST.
 THIS DRAWING IS SUBJECT TO SURVEY AND STATUTORY APPROVALS.
 ALL DIMENSIONS ARE INDICATIVE ONLY AND TO BE CONFIRMED ON SITE.
 ALL FIRE SAFETY INFORMATION HAS BEEN INDICATED AS DIRECTED BY THE
 HURLINGHAM CLUB.
COPYRIGHT IS RESERVED
 COPYING OR REPRODUCTION OF THIS DRAWING OR ELECTRIC DATA WITHOUT
 THE WRITTEN PERMISSION OF 4D STUDIO IS NOT PERMITTED.

KEY	
—	Extent of Licensable activities
—	Extent of Boundary
A	Tennis Pavilion Bar
B	Summer B-B-Q & Bar
C	External Bar - Corporate events (max 10 per yrs)
D	Outdoor Pool Bar
E	South Terrace External Tented Bars
F	Midgrave Terrace Bars
G	Cricket Pavilion Bar
H	Club House
■	Fire Panel
●	Hydrant

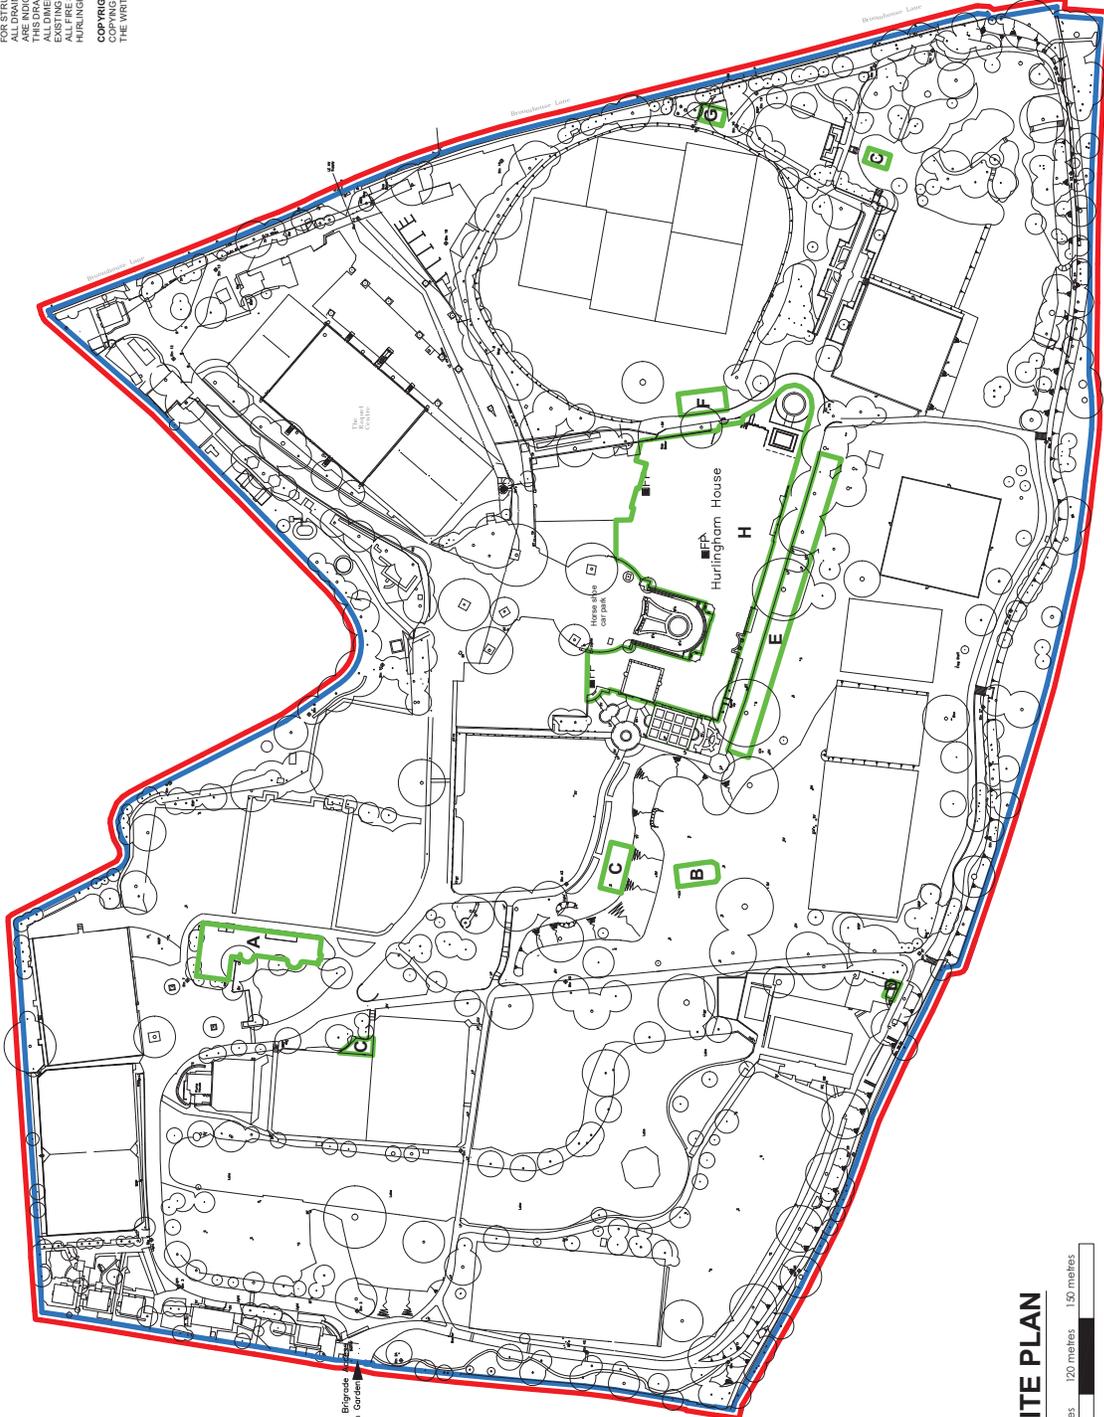


EXISTING SITE PLAN



THE HURLINGHAM CLUB
 RANELAGH GARDENS, FULHAM, LONDON, SW6 3PR

Drawing Title: **EXISTING SITE PLAN**
 Scale: 1:1000 @ A1
 Date: MARCH 2021
 Drawing Number: 4D_2100_AL_001_Rev B

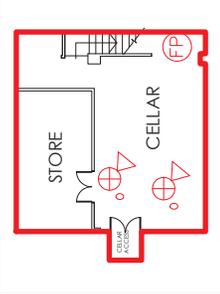

EXISTING POLO BAR BASEMENT FLOOR PLAN

KEY	
[Symbol]	EXTENT OF LICENSABLE ACTIVITIES
[Symbol]	INTERFACE UNIT
[Symbol]	CEILING VOID
[Symbol]	LOOP POWERED BEACON
[Symbol]	OPTICAL SMOKE DETECTOR
[Symbol]	OPTICAL SMOKE DETECTOR C/W SOUNDER BASE
[Symbol]	HEAT DETECTOR
[Symbol]	HEAT DETECTOR C/W JOINDER BASE
[Symbol]	SOUNDER
[Symbol]	BREAK GLASS UNIT
[Symbol]	CALL POINT ONLY
[Symbol]	EXIT SIGNAGE
[Symbol]	EXIT SIGNAGE WITH DIRECTION ARROW
[Symbol]	FIRE POINT COMPRESSING WATER AND CO2 BOTTLE RIGS FOR FIRE SUPPRESSED BY THE LICENSEE

LEGEND	
[Symbol]	PIPE RISE OR DROP
[Symbol]	MECHANICAL JOINT
[Symbol]	TO CUT
[Symbol]	BARREL NIPPLE
[Symbol]	PLUGGED OUTLET
[Symbol]	INSTALLATION CONTROL VALVE
[Symbol]	SPRINKLER AND PIPE
[Symbol]	POSITION OF PIPE HANGER
[Symbol]	RISE TO SPRINKLER
[Symbol]	DROP TO SPRINKLER
[Symbol]	OPEN SPRINKLER
[Symbol]	SIDEWALL SPRINKLER
[Symbol]	DRAIN VALVE
[Symbol]	MULTIPLE CONTROL




THE HURLINGHAM CLUB
RANELAGH GARDENS, FULHAM, LONDON, SW6 3PR

DISCLAIMER
THE HARD COPY ACCOMPANYING THE ELECTRONIC DATA IS THE LEGAL TRANSMISSION OF INFORMATION. THE ELECTRONIC DATA ARE ISSUED ON THE UNDERSTANDING THAT THE USER HAS ACCEPTED THE TERMS AND CONDITIONS OF ANY CONSEQUENCE RESULTING FROM THE USE OR ALTERATION OF THIS INFORMATION IS ACCEPTED.
THE USER AGREES TO CHANGE DURING THE DESIGN DEVELOPMENT PROCESS.
FOR STRUCTURAL DETAILS REFER TO STRUCTURAL ENGINEERS DRAWINGS AND FOR ELECTRICAL DETAILS REFER TO ELECTRICAL ENGINEERS DRAWINGS. THIS DRAWING IS SUBJECT TO SURVEY AND STATUTORY APPROVALS. ALL EXISTING PLANS (DRAWINGS) HAVE BEEN SUPPLIED BY THE HURLINGHAM CLUB. ALL FIRE SAFETY INFORMATION HAS BEEN INDICATED AS DIRECTED BY THE HURLINGHAM CLUB.
COPYRIGHT IS RESERVED
NO PART OF THIS DRAWING OR ELECTRIC DATA WITHOUT THE WRITTEN PERMISSION OF 4D STUDIO IS NOT PERMITTED.



EXISTING BASEMENT FLOOR PLAN

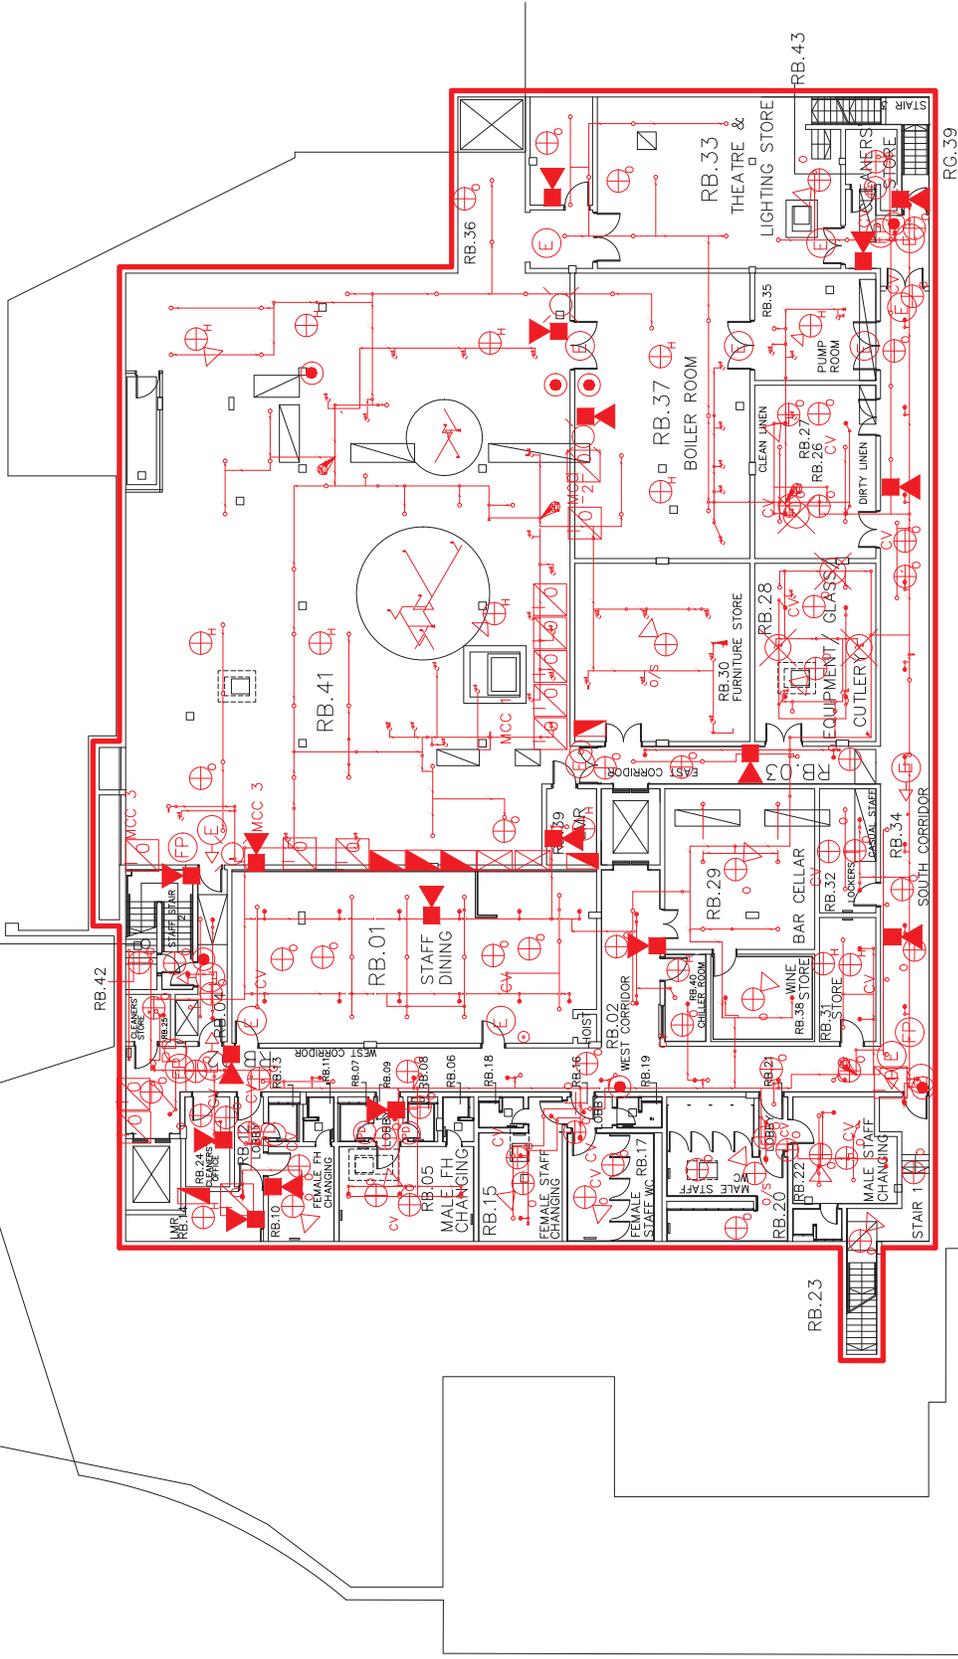

Drawing Title: **EXISTING BASEMENT FLOOR PLAN**
Scale: 1:100 @ A1
Date: MARCH 2021
Drawing Number: 4D_2100_AL_002_Rev B



